
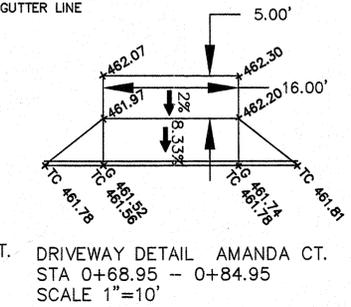
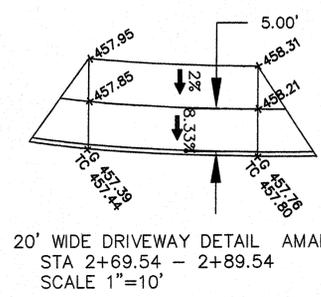
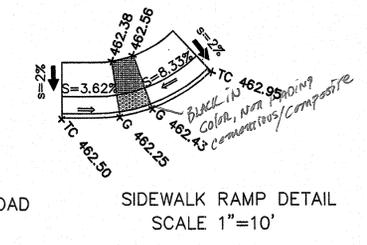
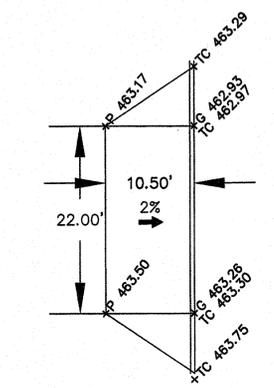
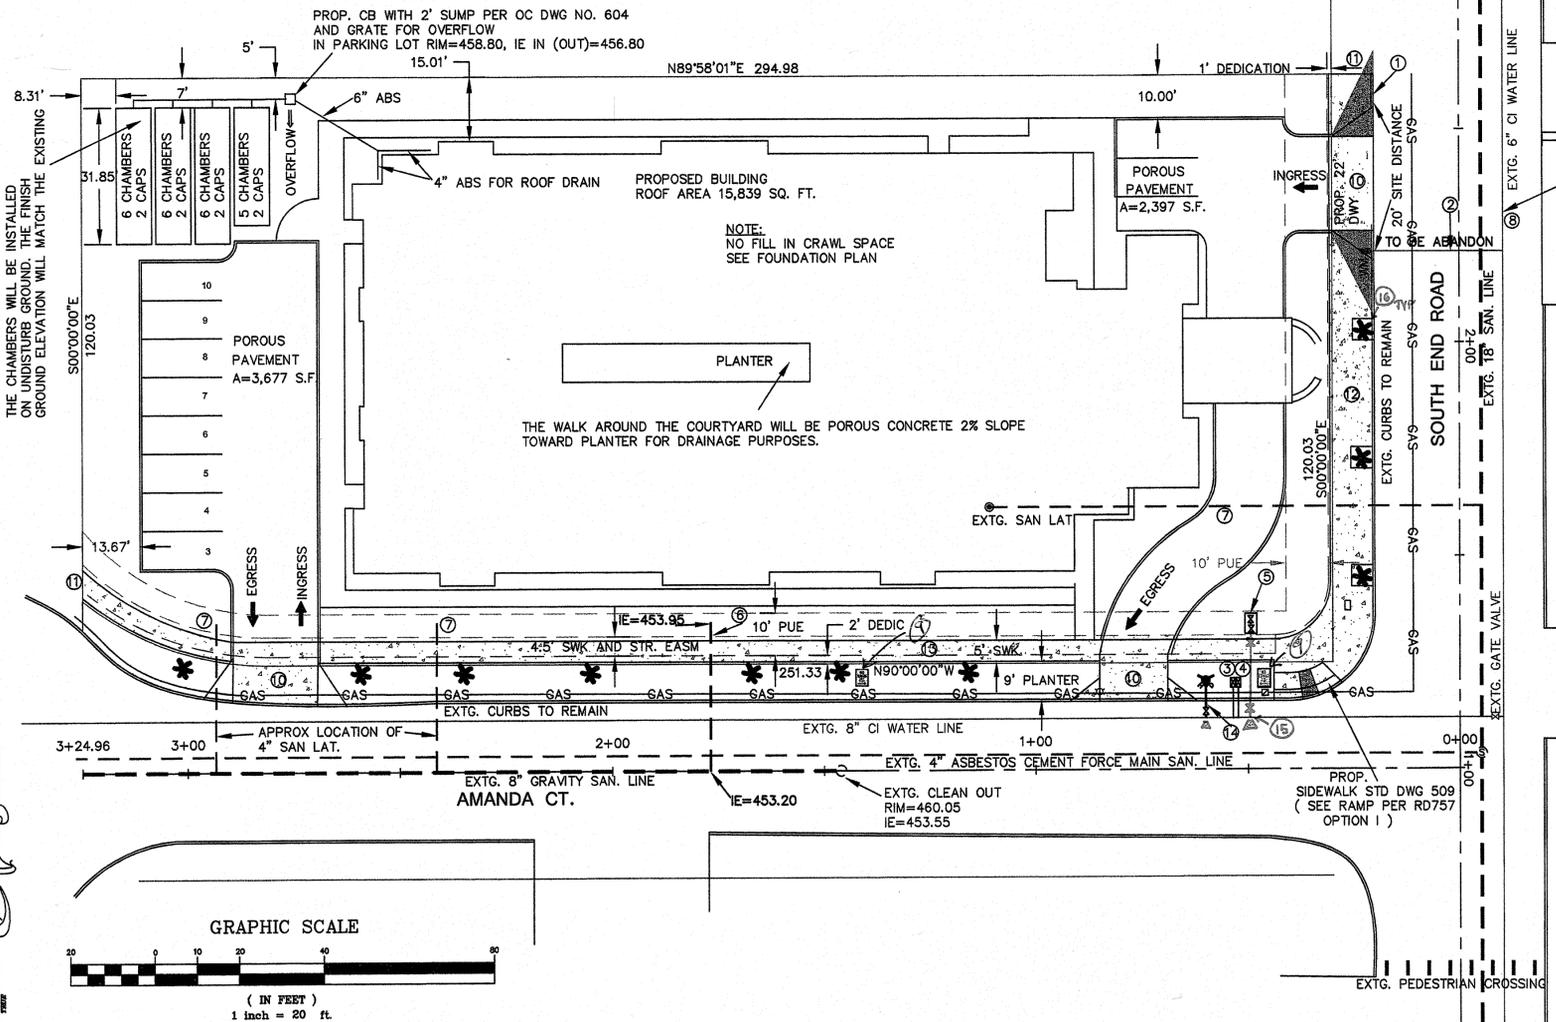


CONSTRUCTION NOTES

- ① CONSTRUCT NEW CURB SEE CITY STD DWG NO. 510
- ② ABANDON EXTG. WATER SERVICE LATERAL AT THE MAIN BY SHUTTING OFF CORP AND REMOVING 1' PIPE. REMOVE THE EXTG WATER METER PLUGGING AND CAPPING THE SERVICE AT THE MAIN WITH CITY WATER DIVISION COORDINATION AND INSPECTION, REMOVAL OF METER BOX AND PLUGGING SERVICES LINE AT METER BOX (TO O.C. PUBLIC WORKS)
- ③ INSTALL A NEW 2" WATER METER PER O.C. STD DWG 404 AND INSTALL APPROVED BACKFLOW ASSSEMBLY OUTSIDE OF ROW
- ④ INSTALL A 1" IRRIGATION METER PER O.C. STD DWG 402 AND INSTALL APPROVED BACKFLOW ASSSEMBLY OUTSIDE OF ROW
- ⑤ INSTALL DOUBLE CHECK BACK FLOW PREVENTER IN THE VAULT PER STD DWG 512 AND 416
- ⑥ INSTALL A NEW 6" SANITARY LATERAL IE=453.20 AT MAIN AT 2% SLOPE IE 453.95 AT PROP. LINE PER O.C STD DWG 310 AND 311. COORDINATE WITH CITY FOR INSPECTIONS OF TRENCH EXCAVATION PRIOR TO EXCAVATING NEAR 4" SANITARY SEWER FORCE LINE.
- ⑦ CAP THE EXISTING 4" SANITARY LATERAL AT PROPERTY LINE
- ⑧ PAY CASH-IN-LIEU FOR REPLACEMENT OF 6" WATER LINE IN SOUTH END ROAD FROM AMANDA CT. CENTERLINE TO NORTHERLY PROPERTY BOUNDARY
- ⑨ *Where? on plan?* INSTALL NO PARKING SIGNS 100 FEET APART PER MUTCC SIGNS DETAILS R7-1L AND R7-1R
- ⑩ STD COMMERCIAL DWY PER STD DWG 505
- ⑪ END OF SIDEWALK MARKER PER O.C. STD DWG NO. 525
- ⑫ CONSTRUCT 10' WIDE SIDEWALK ALONG SOUTH END RD. PER O.C. STD DWG NO. 508
- ⑬ CONSTRUCT 5' WIDE SIDEWALK ALONG AMANDA COURT PER O.C. STD DWG NO. 508
- ⑭ INSTALL FIRE HYDRANT PER OC STD DWG 401. WILL HAVE 3 FEET CLEARANCE IN ANY DIRECTION.
- ⑮ INSTALL 4" FIRE SERVICE PER OC STD DWG NO. 416.
- ⑯ SEE SHEET 02 FOR TREE WELL DETAILS AND STREET TREE DETAILS.

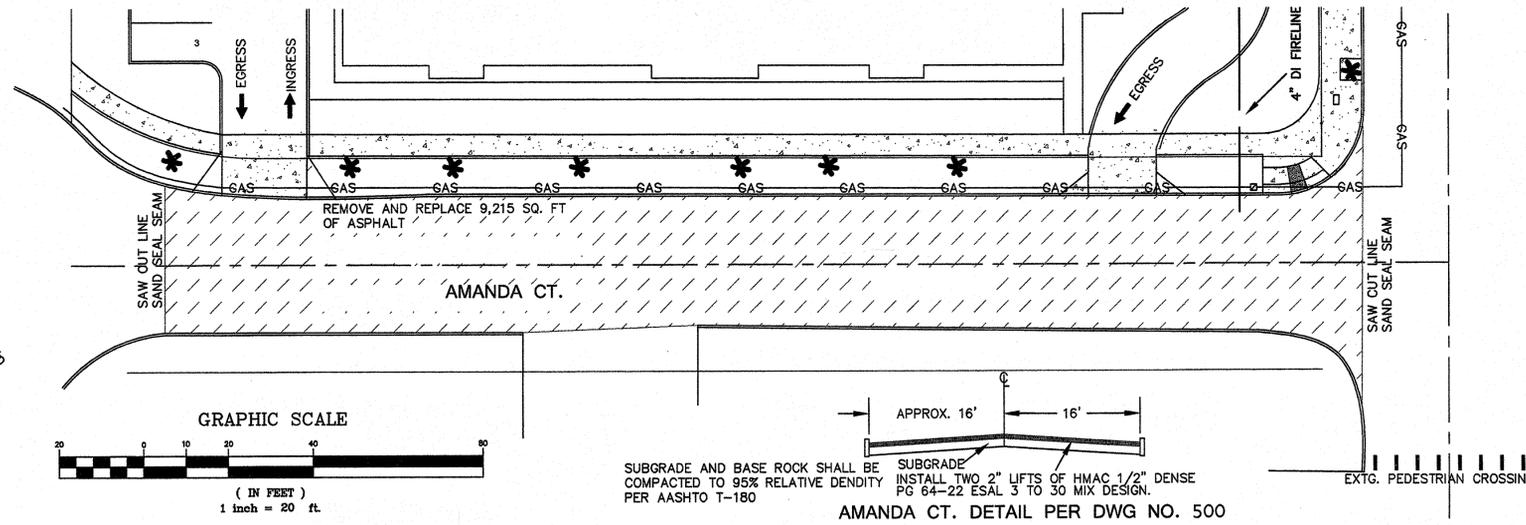

CITY OF OREGON CITY
APPROVED FOR CONSTRUCTION

Approved as Submitted
 Approved as Noted in Red

Engineer: RJM
Planning: _____
Public Works: _____

You shall be responsible for protecting all existing public and private utilities.

Date of Approval: 2/23/2015

REGISTERED PROFESSIONAL ENGINEER
OREGON
1942

FOREIGN CITY

PROJECT NUMBER: SP 14-09 / CN 14-28

PROJECT MANAGER: _____

DESIGNED BY: _____
DRAWN BY: _____
CHECKED BY: _____

STREET IMPROVEMENT AND SITE PLAN
PROJECT: CARE FACILITY OREGON CITY
SP 14-09 / CN 14-28 / CU 14-01

REVISIONS

NO.	DATE	DESCRIPTION

DRAWING NUMBER: **C1**
SHEET 2 OF 8